


Los Angeles Metropolitan Medical Center-Hawthorne Campus Facility No. 11845

BLD-02914 - Original
Building - Bldg 01

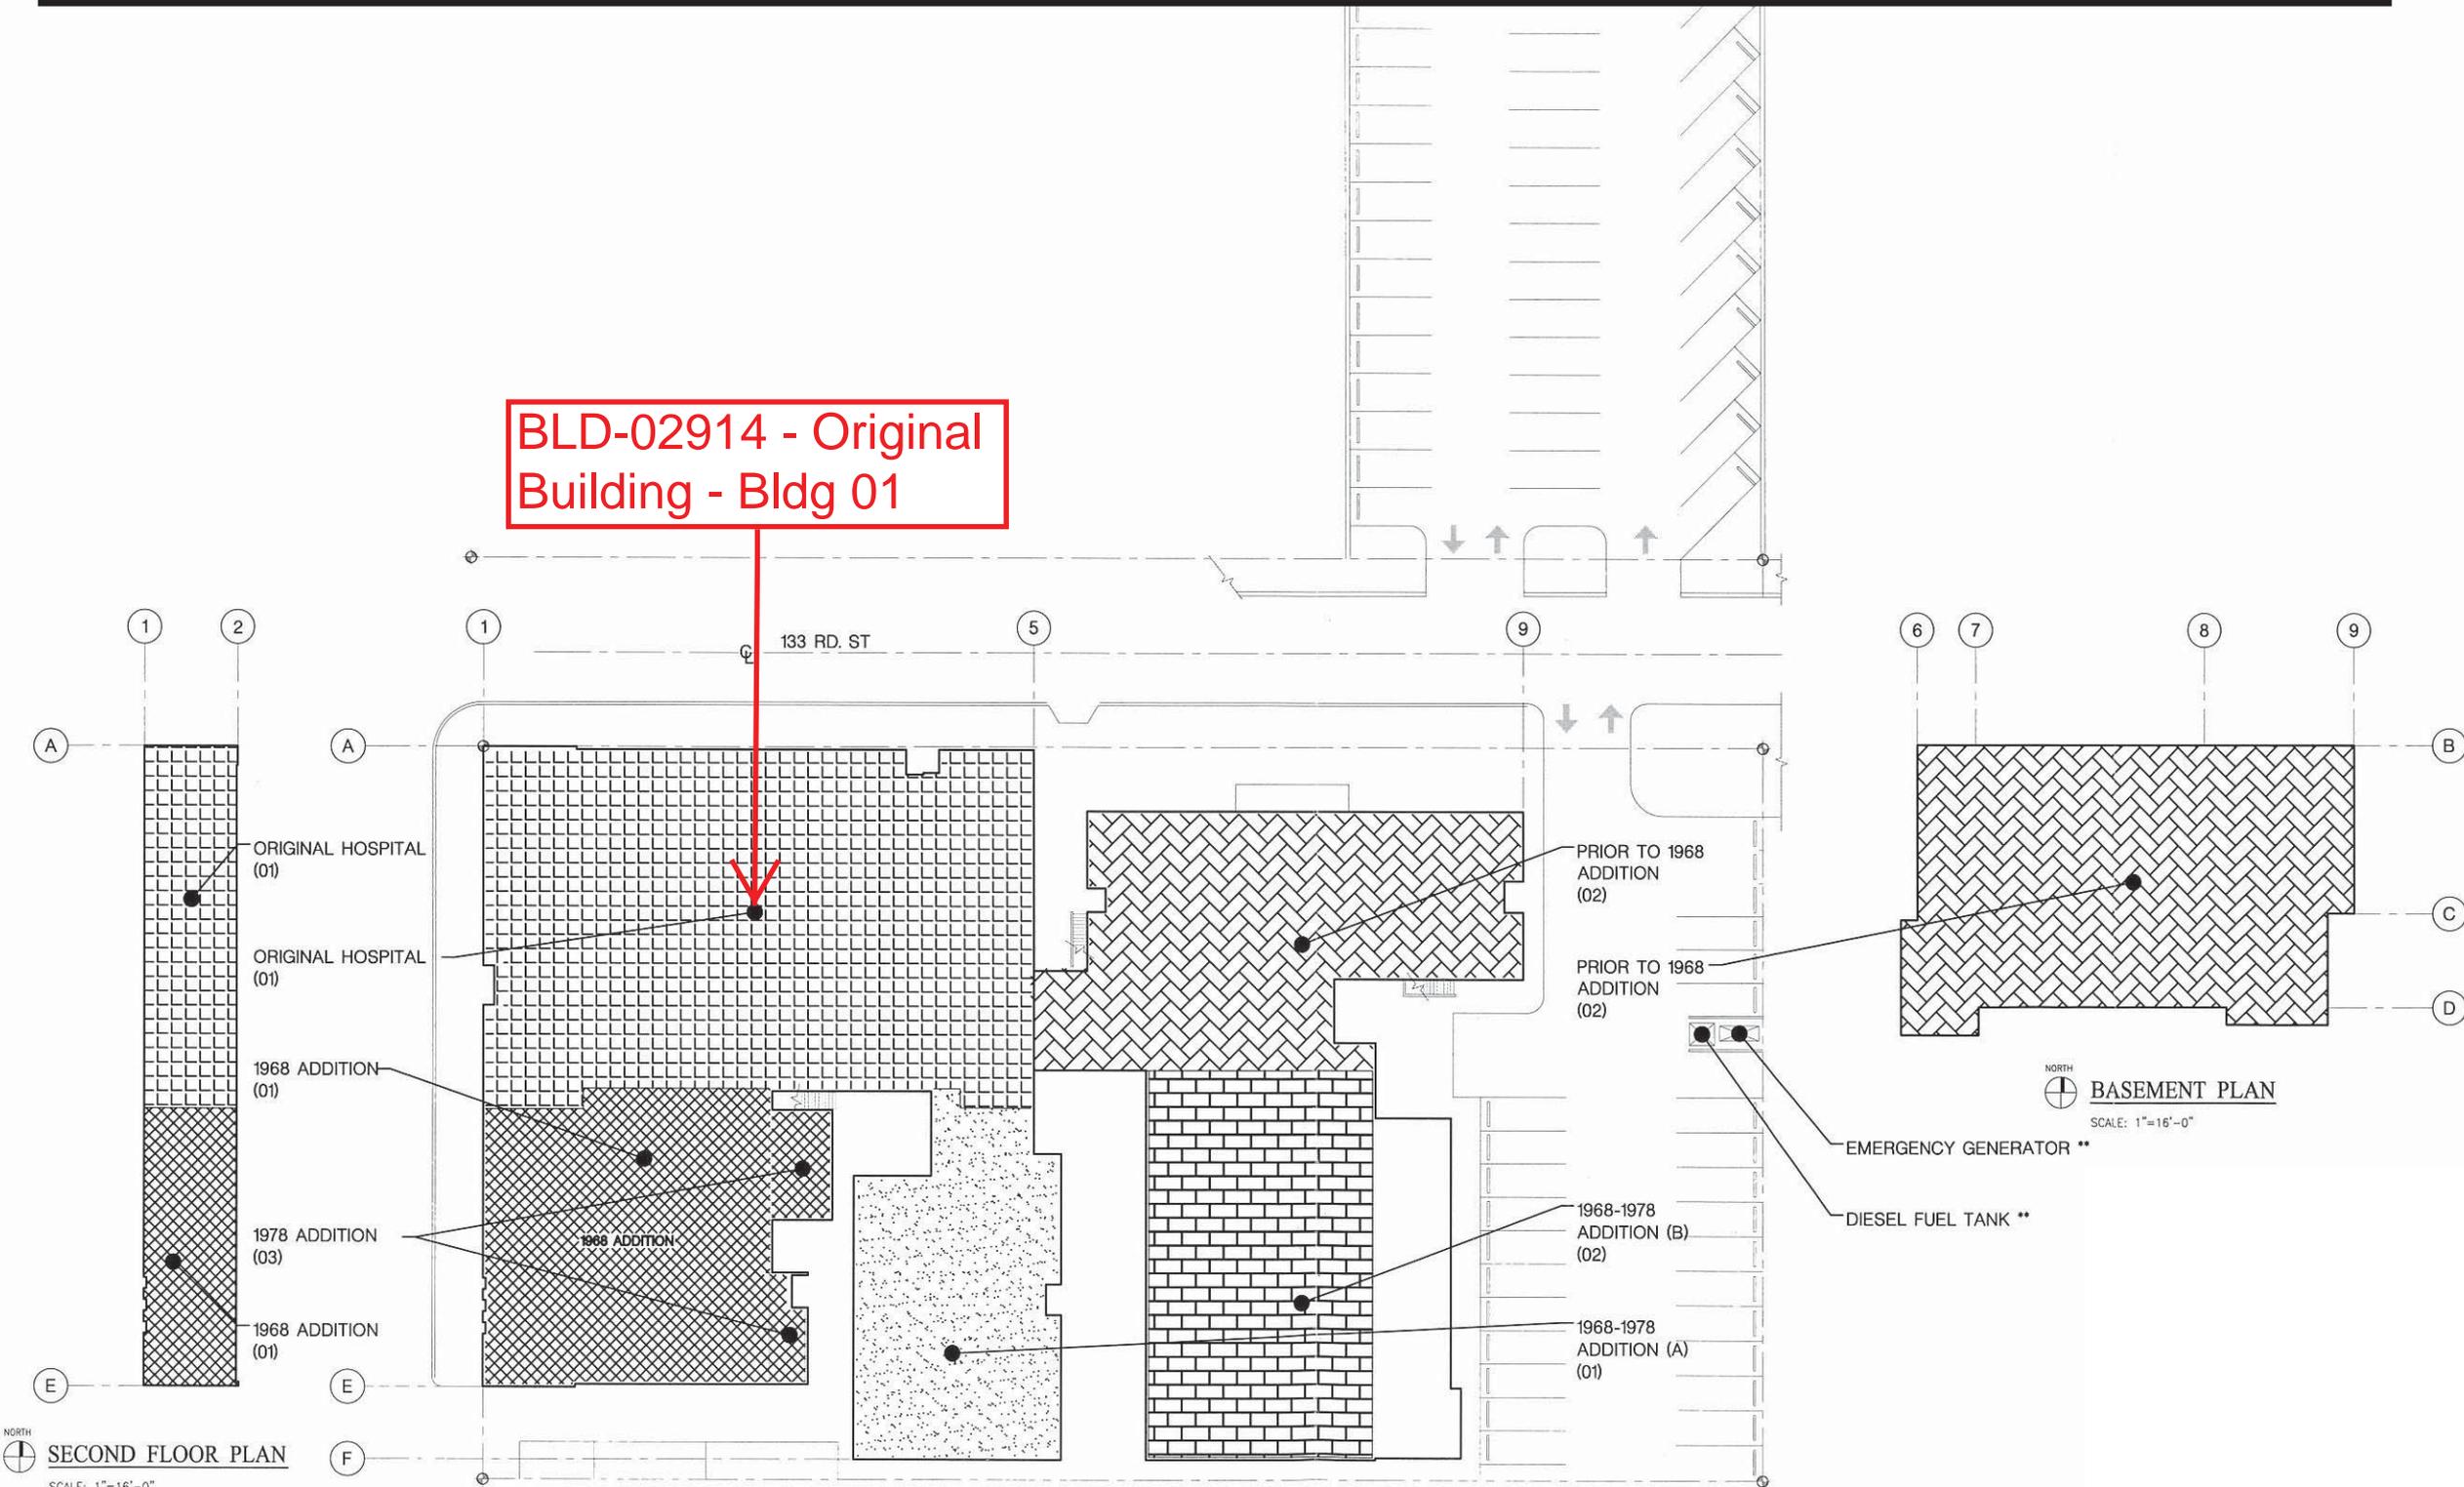

NORTH
SECOND FLOOR PLAN
SCALE: 1"=16'-0"

NORTH
FLOOR PLAN
SCALE: 1"=16'-0"

NORTH
BASEMENT PLAN
SCALE: 1"=16'-0"